

**AGENDA**

**SCHOOL DISTRICT OF NEW GLARUS  
FACILITITES, TRANSPORTATION & TECHNOLOGY COMMITTEE MEETING  
MONDAY, DECEMBER 16, 2024  
HIGH SCHOOL LIBRARY/MEDIA CENTER, ROOM 183 JOIN ZOOM MEETING USING  
LINK  
HTTPS://US02WEB.ZOOM.US/J/85678041602?PWD=6O7GODBGJFTJIRNTOAM6  
FX14DGB38A.1 BY PHONE USING 1-646-568-7788 MEETING ID 856 7804 1602 &  
PASSWORD 060021  
1701 2ND STREET  
NEW GLARUS, WISCONSIN 53574  
6:45 PM**

- I. **Call to Order**
- II. **Primary School and Elementary Renovation Update**
- III. **Concession/Bathroom Building Redesign by Local Architect to  
Reduct Cost** **2**



JEFFREY J LAHEY ARCHITECT  
9110 COUNTY ROAD G  
MOUNT HOREB, WI 53572  
jlahey@jtds.net



NO.	ISSUANCE	DATE
1	PRELIM	10-24-24
2	REVISION	11-04-24
3	REVISION	11-15-24
4	REVISION	12-03-24
5	REVISION	12-16-24

PLUMBING FIXTURES

ITEM (ASSEMBLY A-5)	PERMITTED/ ALLOWED/ REQUIRED		PROVIDED		NOTES
	MEN (412) 1/75	WOMEN (220) 1/40	MEN (412)	WOMEN (210)	
RESTROOMS: MEN (412) WOMEN (210)					
URINALS: (TABLE 2902.1)	3	0	3	0	
WATER CLOSETS: (TABLE 2902.1)	2.5	5.5	2.5	5.5	
LAVATORIES: (TABLE 2902.1)	3	3	3	3	
FACILITY:					
DRINKING FOUNTAINS: (TABLE 2902.1)	0		0		WATER DISPENSED AS REQ'D
SERVICE SINKS: (TABLE 2902.1)	1		1		
UNISEX REST ROOM -	1 TOILET, 1 LAV		1 TOILET, 1 LAV		

CURRENT DESIGN ALLOWS 632 OCCUPANTS PER TABLE 2902.1

36" EAVE AND RAKE OVERHANG  
WITH 'SWISS' BRACES

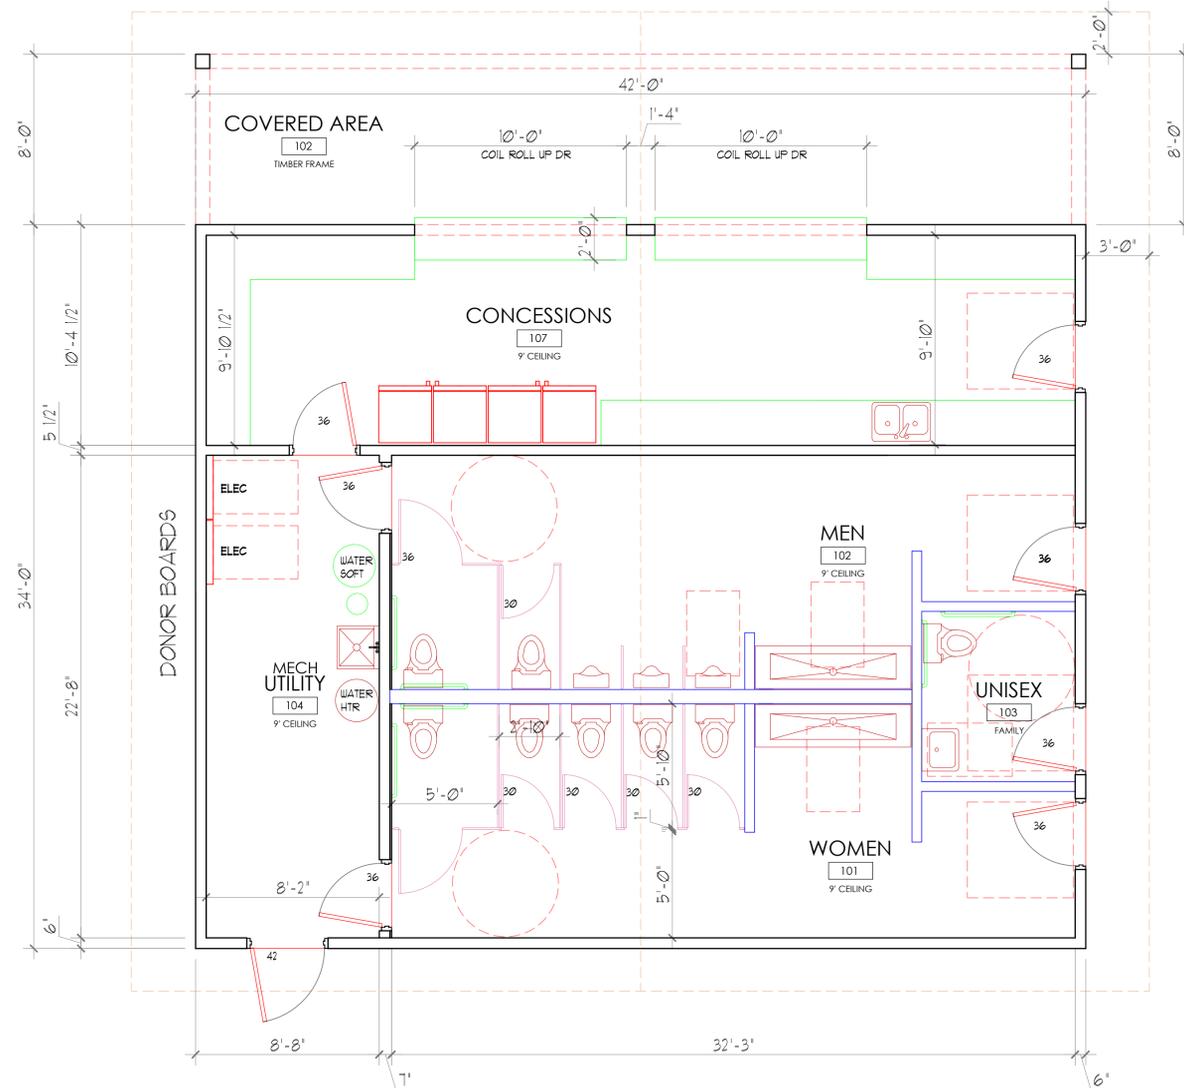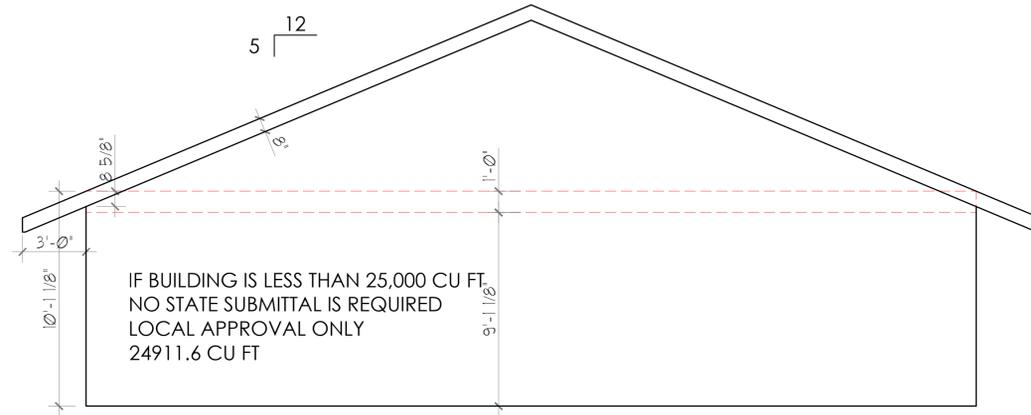

**1** PRELIMINARY FLOOR PLAN  
SCALE: 1/4"=1'-0"

CERTIFICATION AND SEAL

NEW PROJECT FOR:  
**NG SCHOOLS CONCESSIONS**

2ND STREET NEW GLARUS, WI 53574


DRAWING TITLE:	FLOOR PLAN
PROJECT NUMBER:	24043
DRAWN BY:	JJL
CHECKED BY:	JJL
SHEET NUMBER:	<b>A201</b>



JEFFREY J LAHEY ARCHITECT  
9110 COUNTY ROAD G  
MOUNT HOREB, WI 53572  
jlahey@jtds.net


NO.	ISSUANCE	DATE
1	PRELIM	10-24-24
2	REVISION	11-04-24
3	REVISION	11-15-24
4	REVISION	12-03-24
5	REVISION	12-16-24

CERTIFICATION AND SEAL

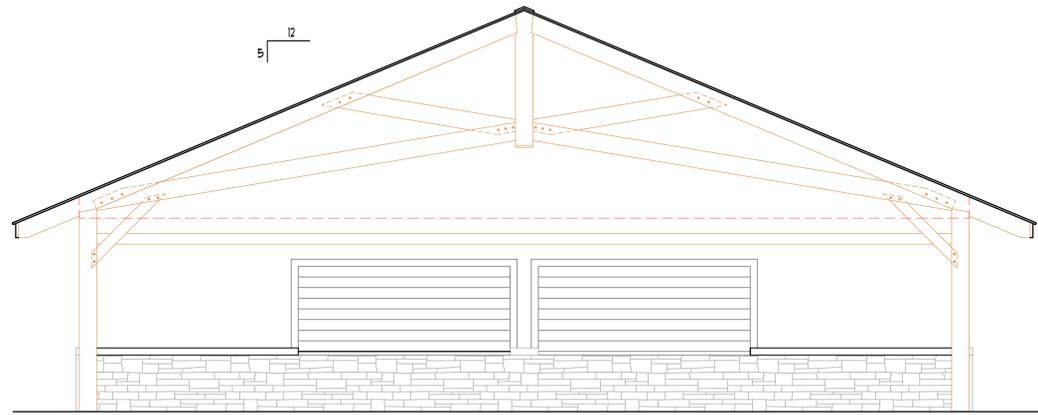


METAL ROOF TO MATCH ENTRY TICKET BOOTH,  
PRESS BOX AND FUTURE PAVILLION  
TIMBER FRAME SIMILAR DESIGN AS TICKET  
BOOTH AND FUTURE PAVILLION  
SIDING  
ROLLING GRILL DOOR  
BRICK VENEER


**1** NORTH ELEVATION  
SCALE: 1/4"=1'-0"  
FACING FIELD

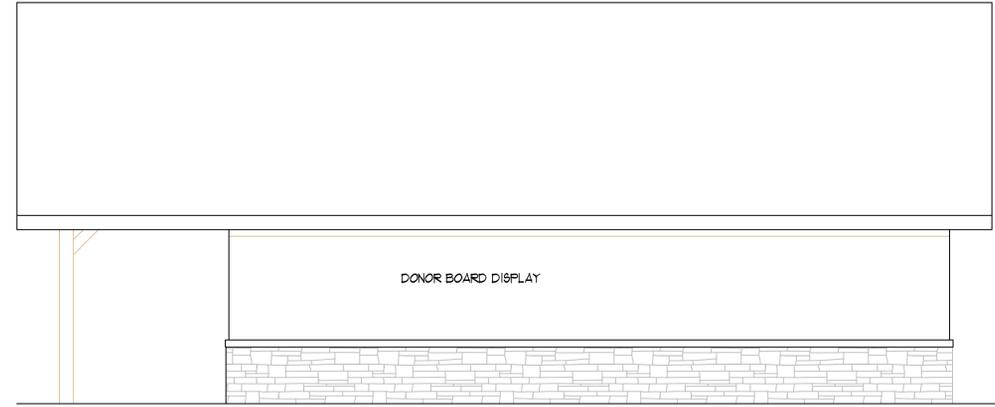

**2** WEST ELEVATION  
SCALE: 1/4"=1'-0"

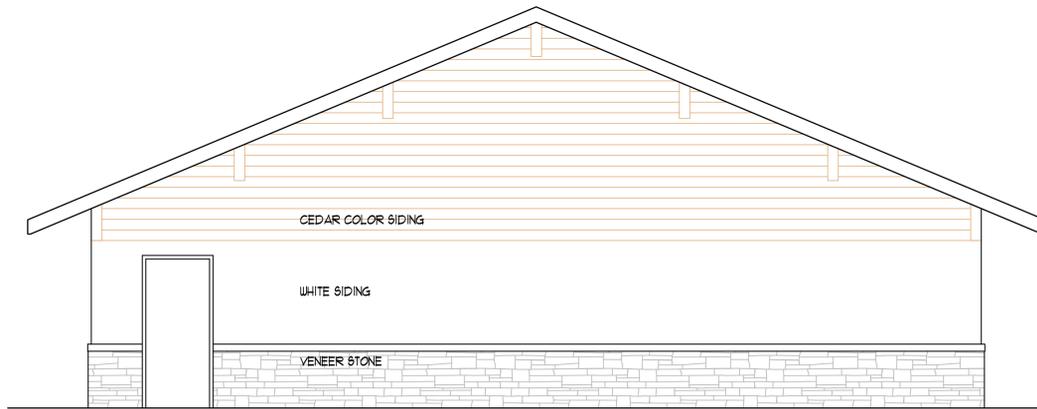

**3** SOUTH ELEVATION  
SCALE: 1/4"=1'-0"

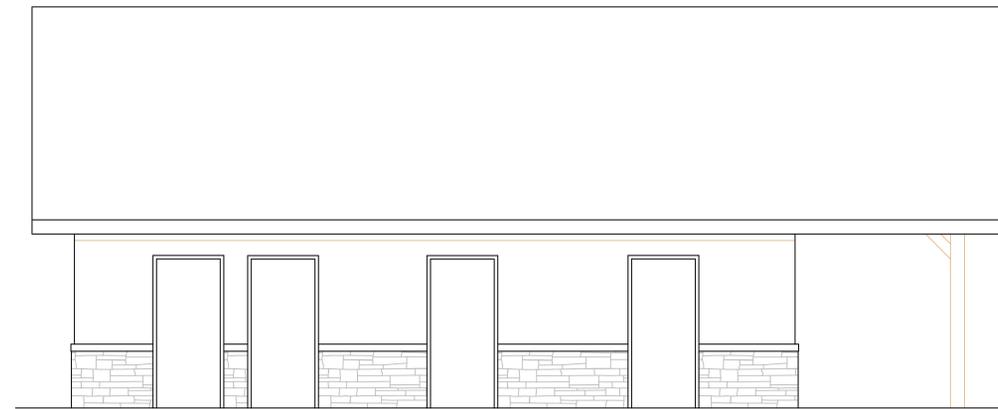

**4** EAST ELEVATION  
SCALE: 1/4"=1'-0"

NEW PROJECT FOR:  
**NG SCHOOLS CONCESSIONS**

2ND STREET NEW GLARUS, WI 53574


DRAWING TITLE:	ELEVATIONS
PROJECT NUMBER:	24043
DRAWN BY:	JJL
CHECKED BY:	JJL
SHEET NUMBER:	<b>A301</b>



9110 COUNTY ROAD G  
MOUNT HOREB, WI 53572  
jlahey@jtds.net

NO.	ISSUANCE	DATE
1	PRELIM	10-24-24
2	REVISION	11-04-24
3	REVISION	11-15-24
4	REVISION	12-03-24
5	REVISION	12-16-24

CERTIFICATION AND SEAL

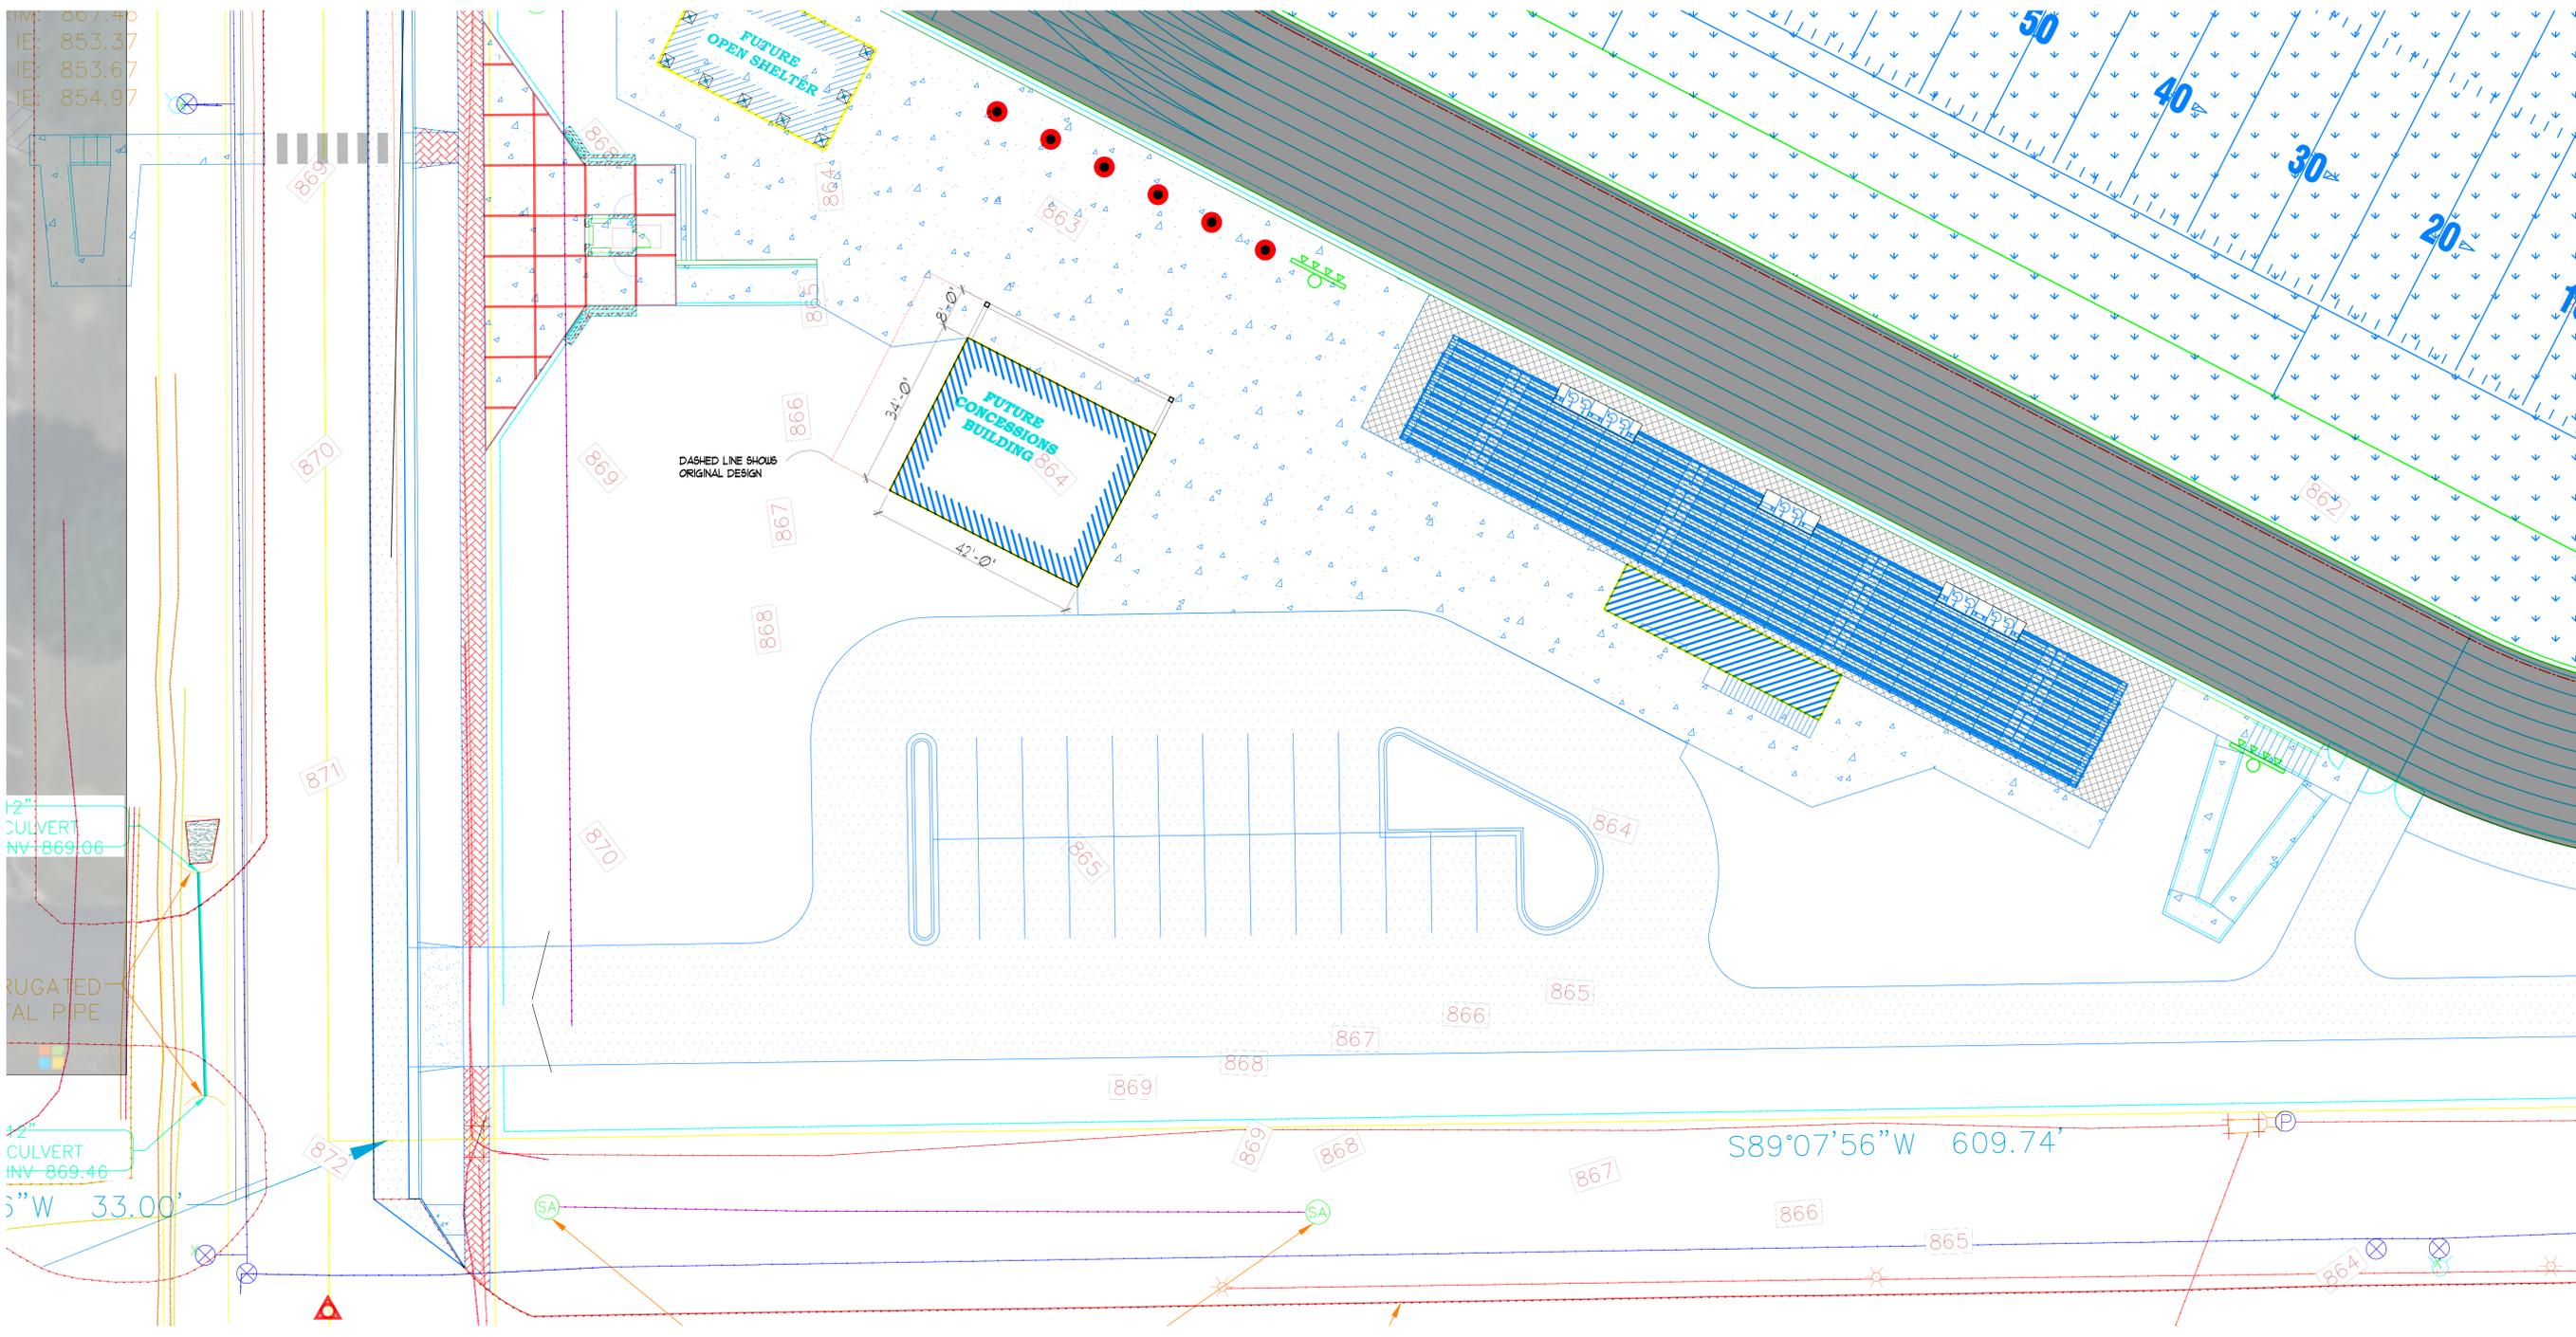

867.46  
 853.37  
 853.67  
 854.97

12" CULVERT  
 INV 869.06

RUGATED  
 TAL PIPE

12" CULVERT  
 INV 869.46

36" W 33.00'

NEW PROJECT FOR:  
**NG SCHOOLS CONCESSIONS**

2ND STREET NEW GLARUS, WI 53574

**1 PRELIMINARY SITE PLAN**

SCALE: 1/16"=1'-0"

DRAWING TITLE:  
SITE PLAN

PROJECT NUMBER: 24043  
 DRAWN BY: JJL  
 CHECKED BY: JJL

SHEET NUMBER:  
**C101**

#### **IV. Adjourn**

PURSUANT TO APPLICABLE LAW, NOTICE IS HEREBY GIVEN THAT A QUORUM OR A MAJORITY OF THE NEW GLARUS SCHOOL DISTRICT BOARD MEMBERS MAY ATTEND THIS MEETING. INFORMATION PRESENTED AT THIS MEETING MAY HELP FORM THE RATIONALE BEHIND FUTURE ACTIONS THAT MAY BE TAKEN BY THE NEW GLARUS SCHOOL DISTRICT BOARD.

UPON REQUEST TO THE DISTRICT OFFICE, SUBMITTED TWENTY-FOUR (24) HOURS IN ADVANCE, THE DISTRICT SHALL MAKE REASONABLE ACCOMMODATIONS INCLUDING THE PROVISION OF INFORMATIONAL MATERIAL IN AN ALTERNATIVE FORMAT FOR A DISABLED PERSON TO BE ABLE TO ATTEND THIS MEETING.